

LIGHTING
SITE PLAN
 SCALE: 1/32" = 1'-0"
 EXISTING WAREHOUSE/STORAGE BLDG.
 PARCEL NO. 3108140020100



WEIR ANDERSON ASSOCIATES, INC.
 ARCHITECTS & ENGINEERS
 1420 4th Street
 San Rafael, CA 94901
 T. 415.485.9997
 www.wandson.com



ARLINGTON

6804 204TH, ST.
 ARLINGTON, WA

APN: 052-15-106
 MARK DATE OCCUPATION
 02/11/23 PERMIT


SCALE: AS INDICATED
 DRAWN BY: MD
 CHECKED BY: AF
 JOB NUMBER: 22019

SHEET TITLE
 LIGHTING
 SITE PLAN

DRAWING

E-100

COPYRIGHTS 2023
 ALL RIGHTS RESERVED

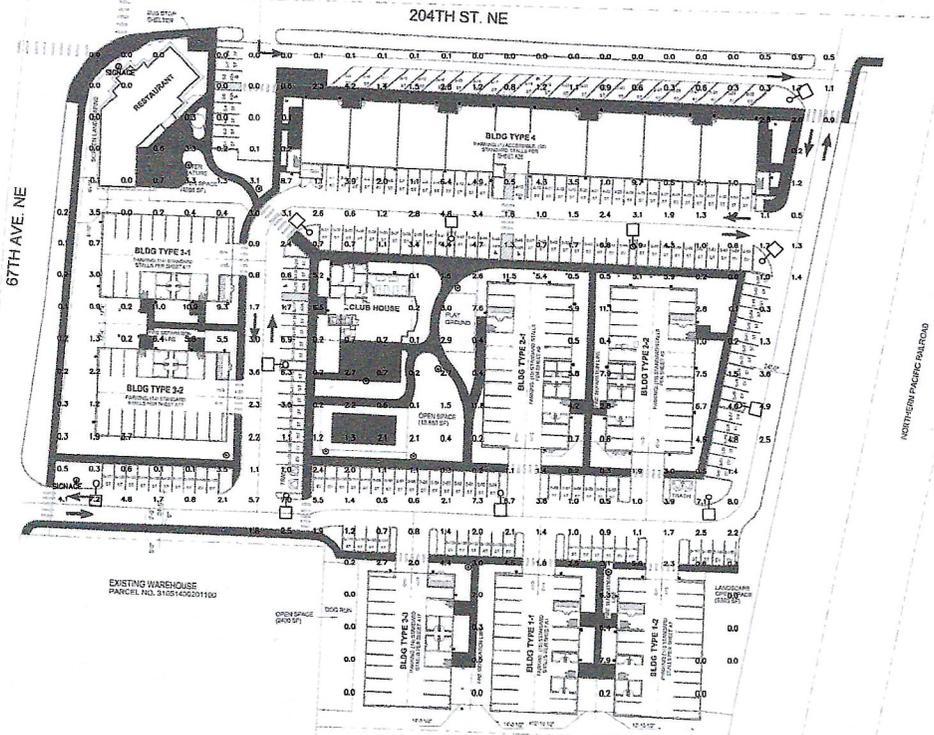

PHOTOMETRICS
SITE PLAN
 SCALE: 1/32" = 1'-0"



Weir|ANDREWSON
ASSOCIATES, INC.
 ARCHITECTS & ENGINEERS
 1430 4th Street
 San Rafael, CA 94901
 T: 415 485 9797
 WWW.WOASOC.COM



ARLINGTON

6804 204TH, ST.
 ARLINGTON, WA

APN: 052-19-100
 MARK DATE DESCRIPTION
 06/10/22 POWER

SCALE: AS INDICATED
 DRAWN BY: MD
 CHECKED BY: AF
 JOB NUMBER: 22010
 SHEET TITLE

PHOTOMETRICS
 DRAWING
E-101
 COPYRIGHTS 2023

